

GRAY ORGANSCHI

ARCHITECTURE
 NYC DDC Department of Design and Construction



STARLIGHT PARK
 Comfort Station
 06/27/2016




Scale 1" = 40'



Existing Site Plan

BRONX RIVER

I-895

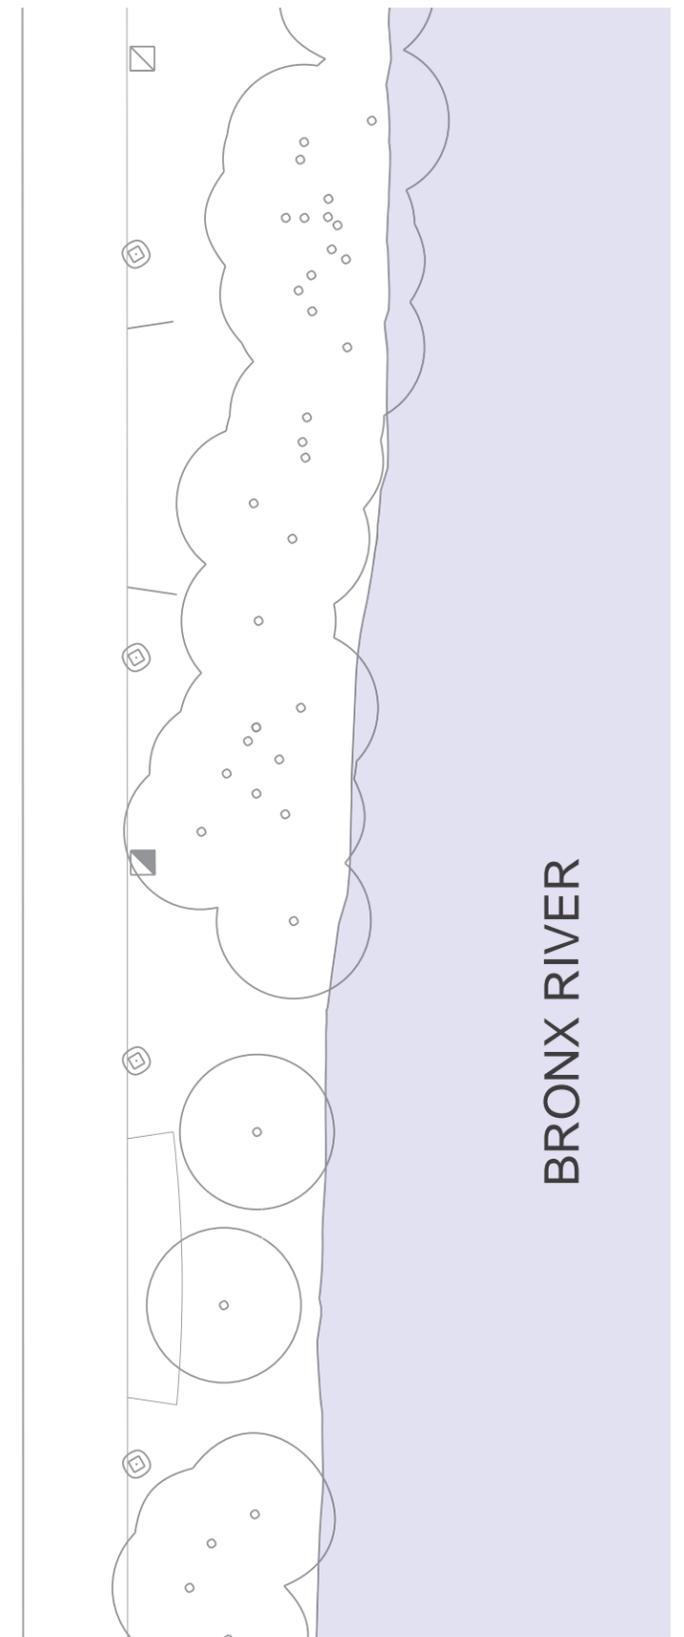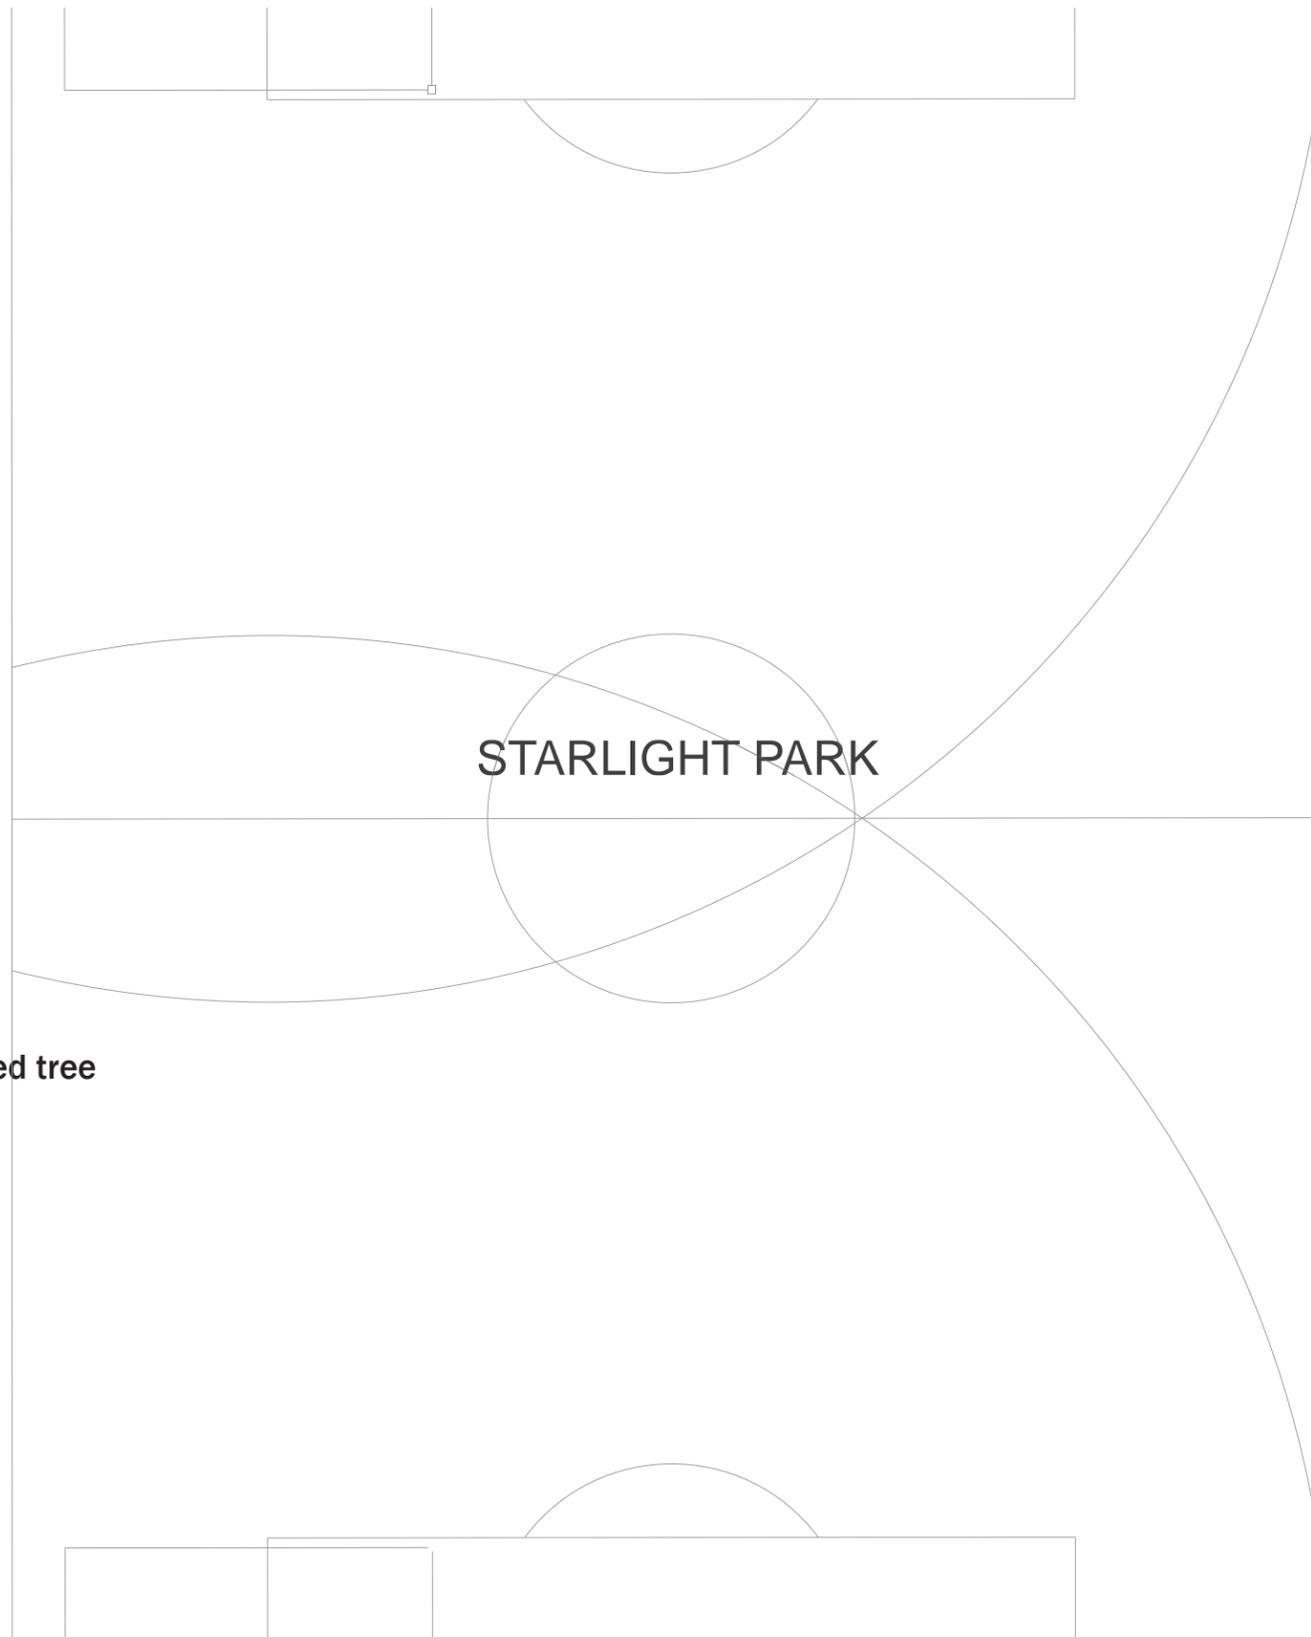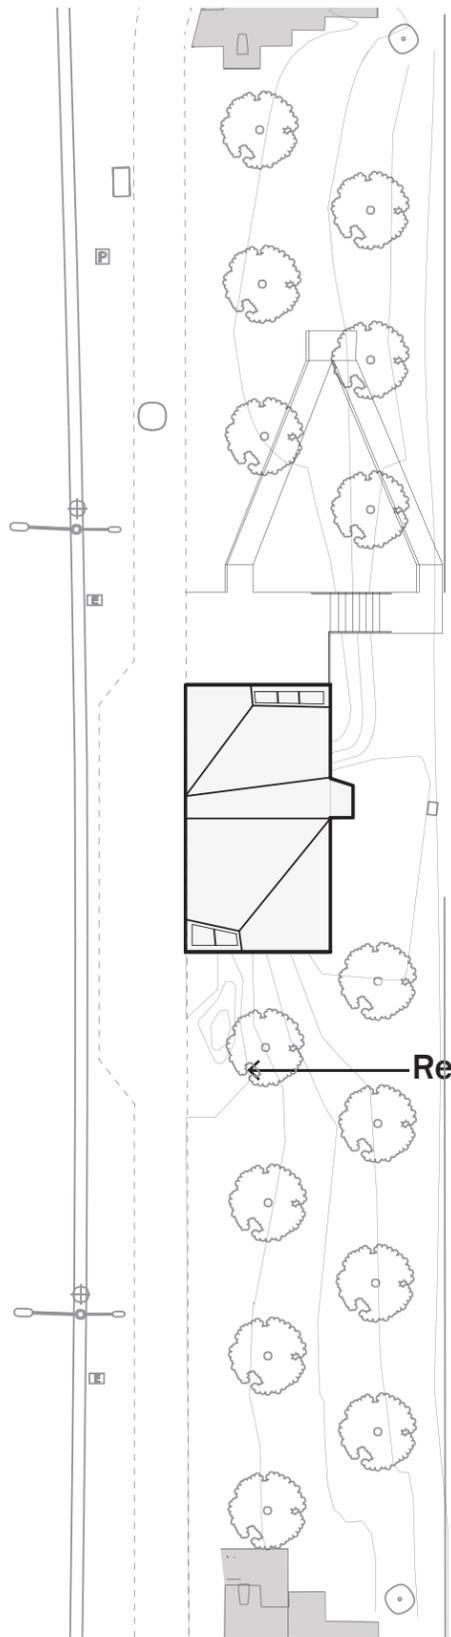

GRAY ORGANSCHI

ARCHITECTURE
NYC DDC Department of Design and Construction





STARLIGHT PARK
Comfort Station
06/27/2016

Scale 1/16" = 1'



Proposed Site Plan - Approved
Preliminary Review

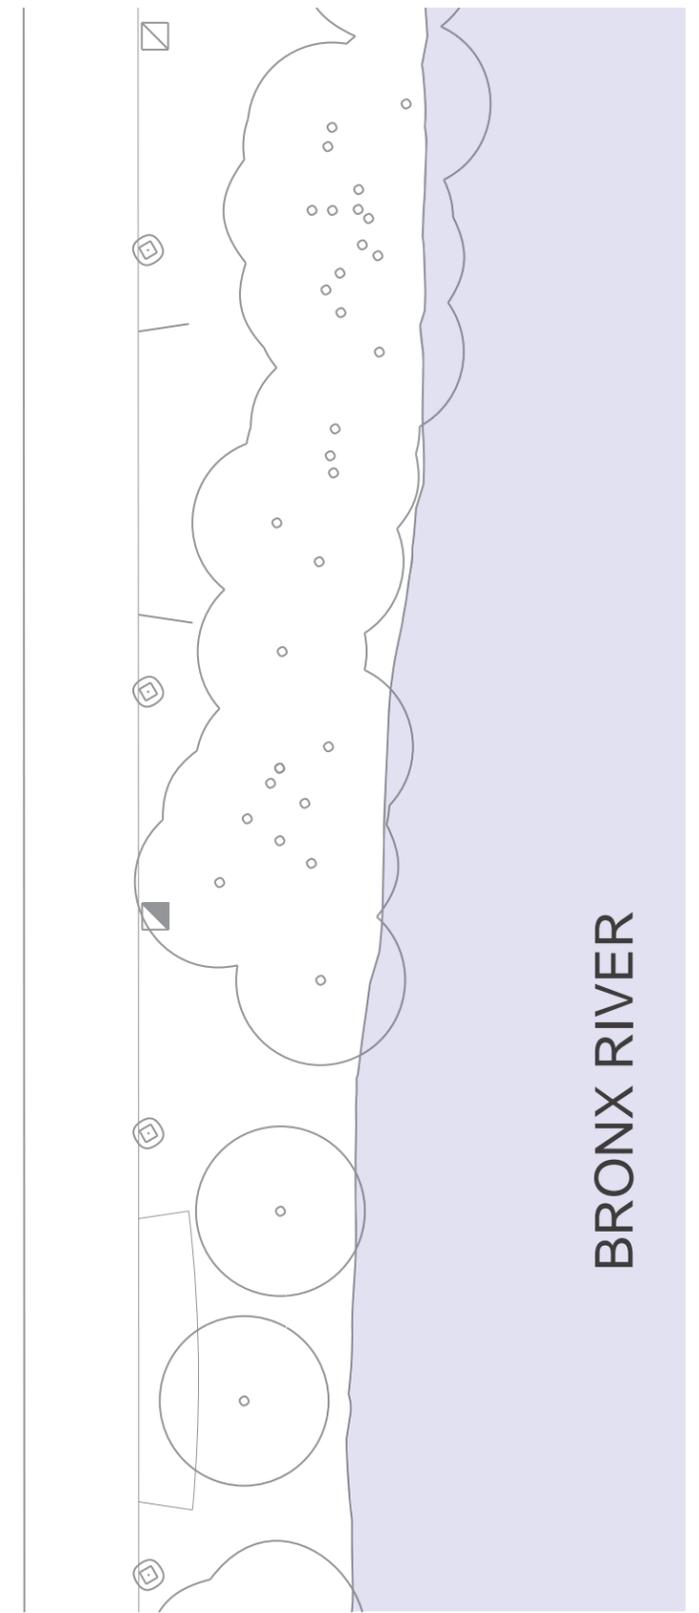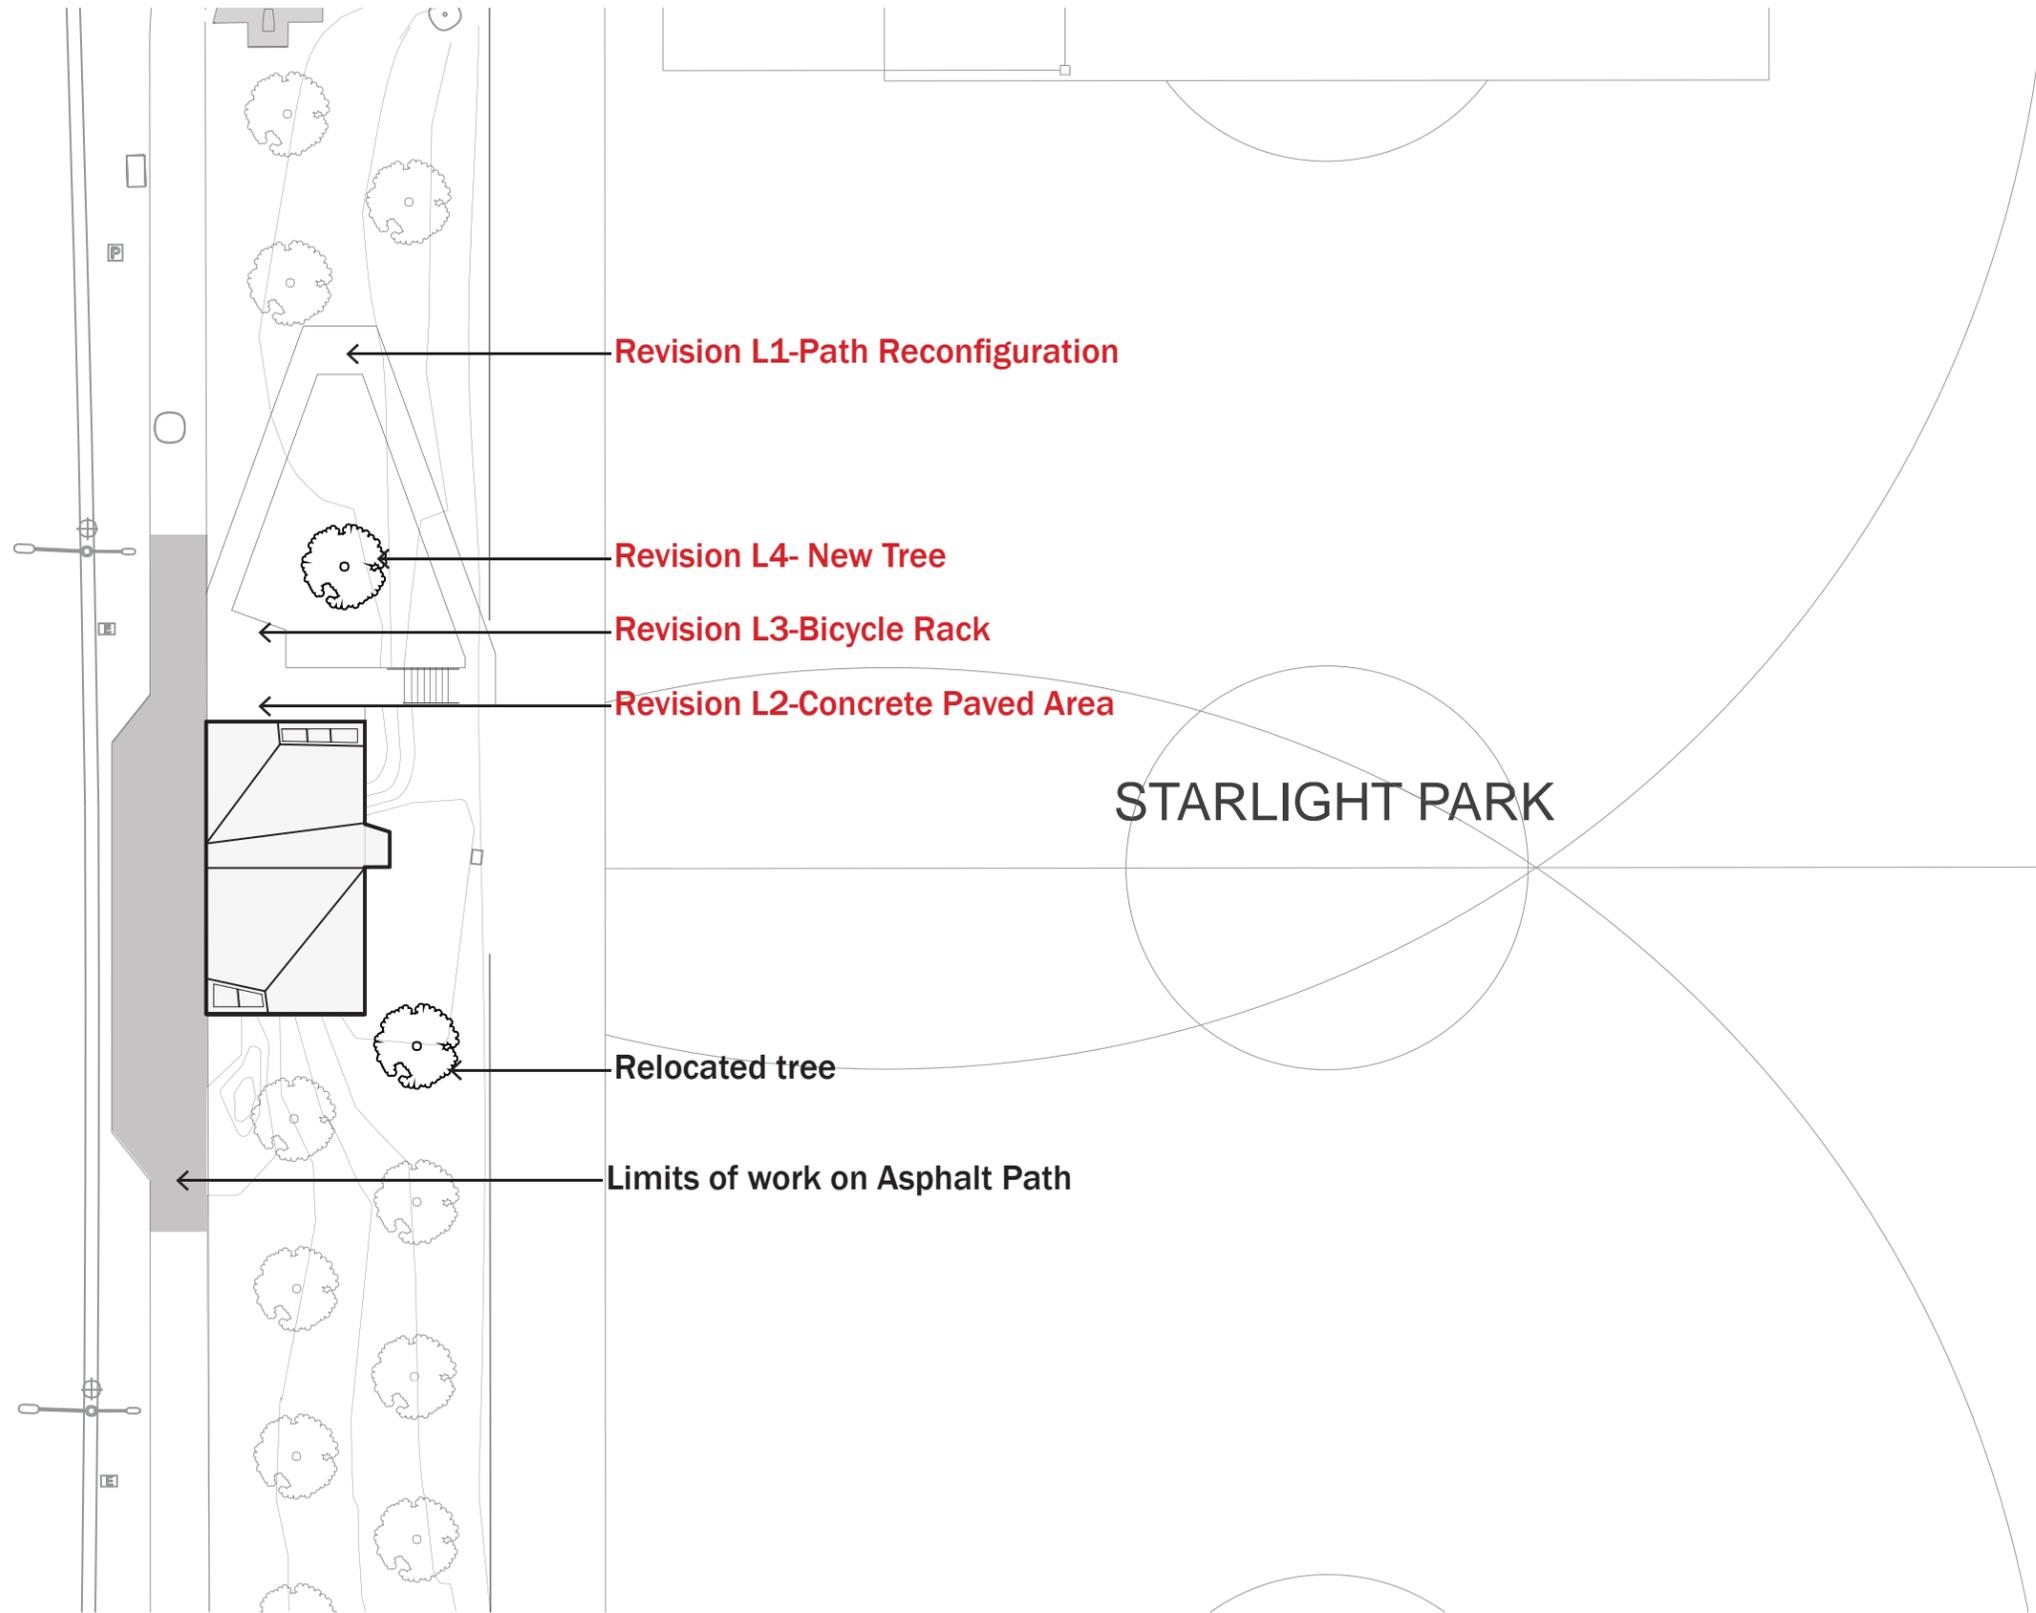

GRAY ORGANSCHI

ARCHITECTURE
 NYC DDC Department of Design and Construction




NYC Parks


STARLIGHT PARK
 Comfort Station
 06/27/2016

Scale 1" = 40'



Proposed Site Plan - Final Review

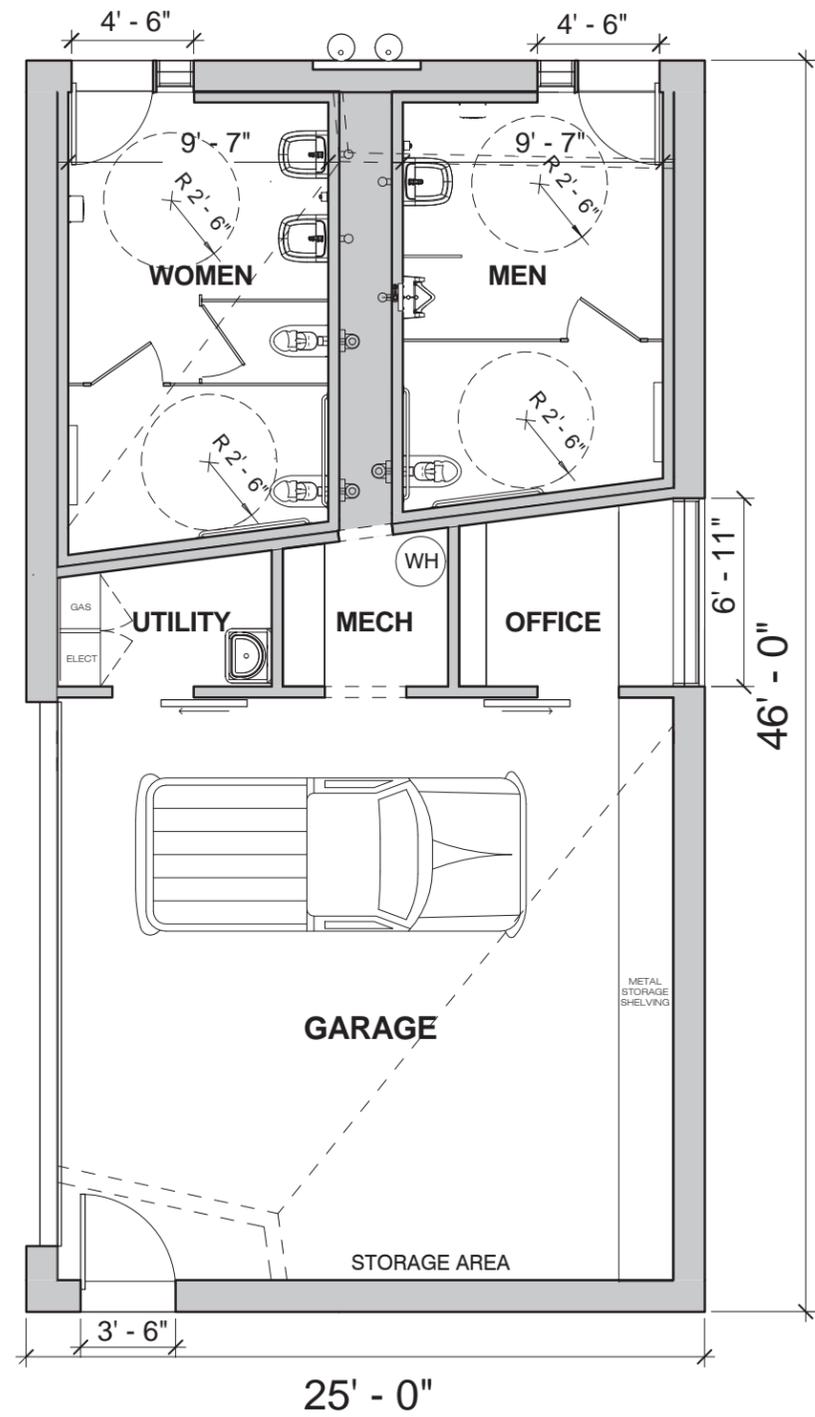

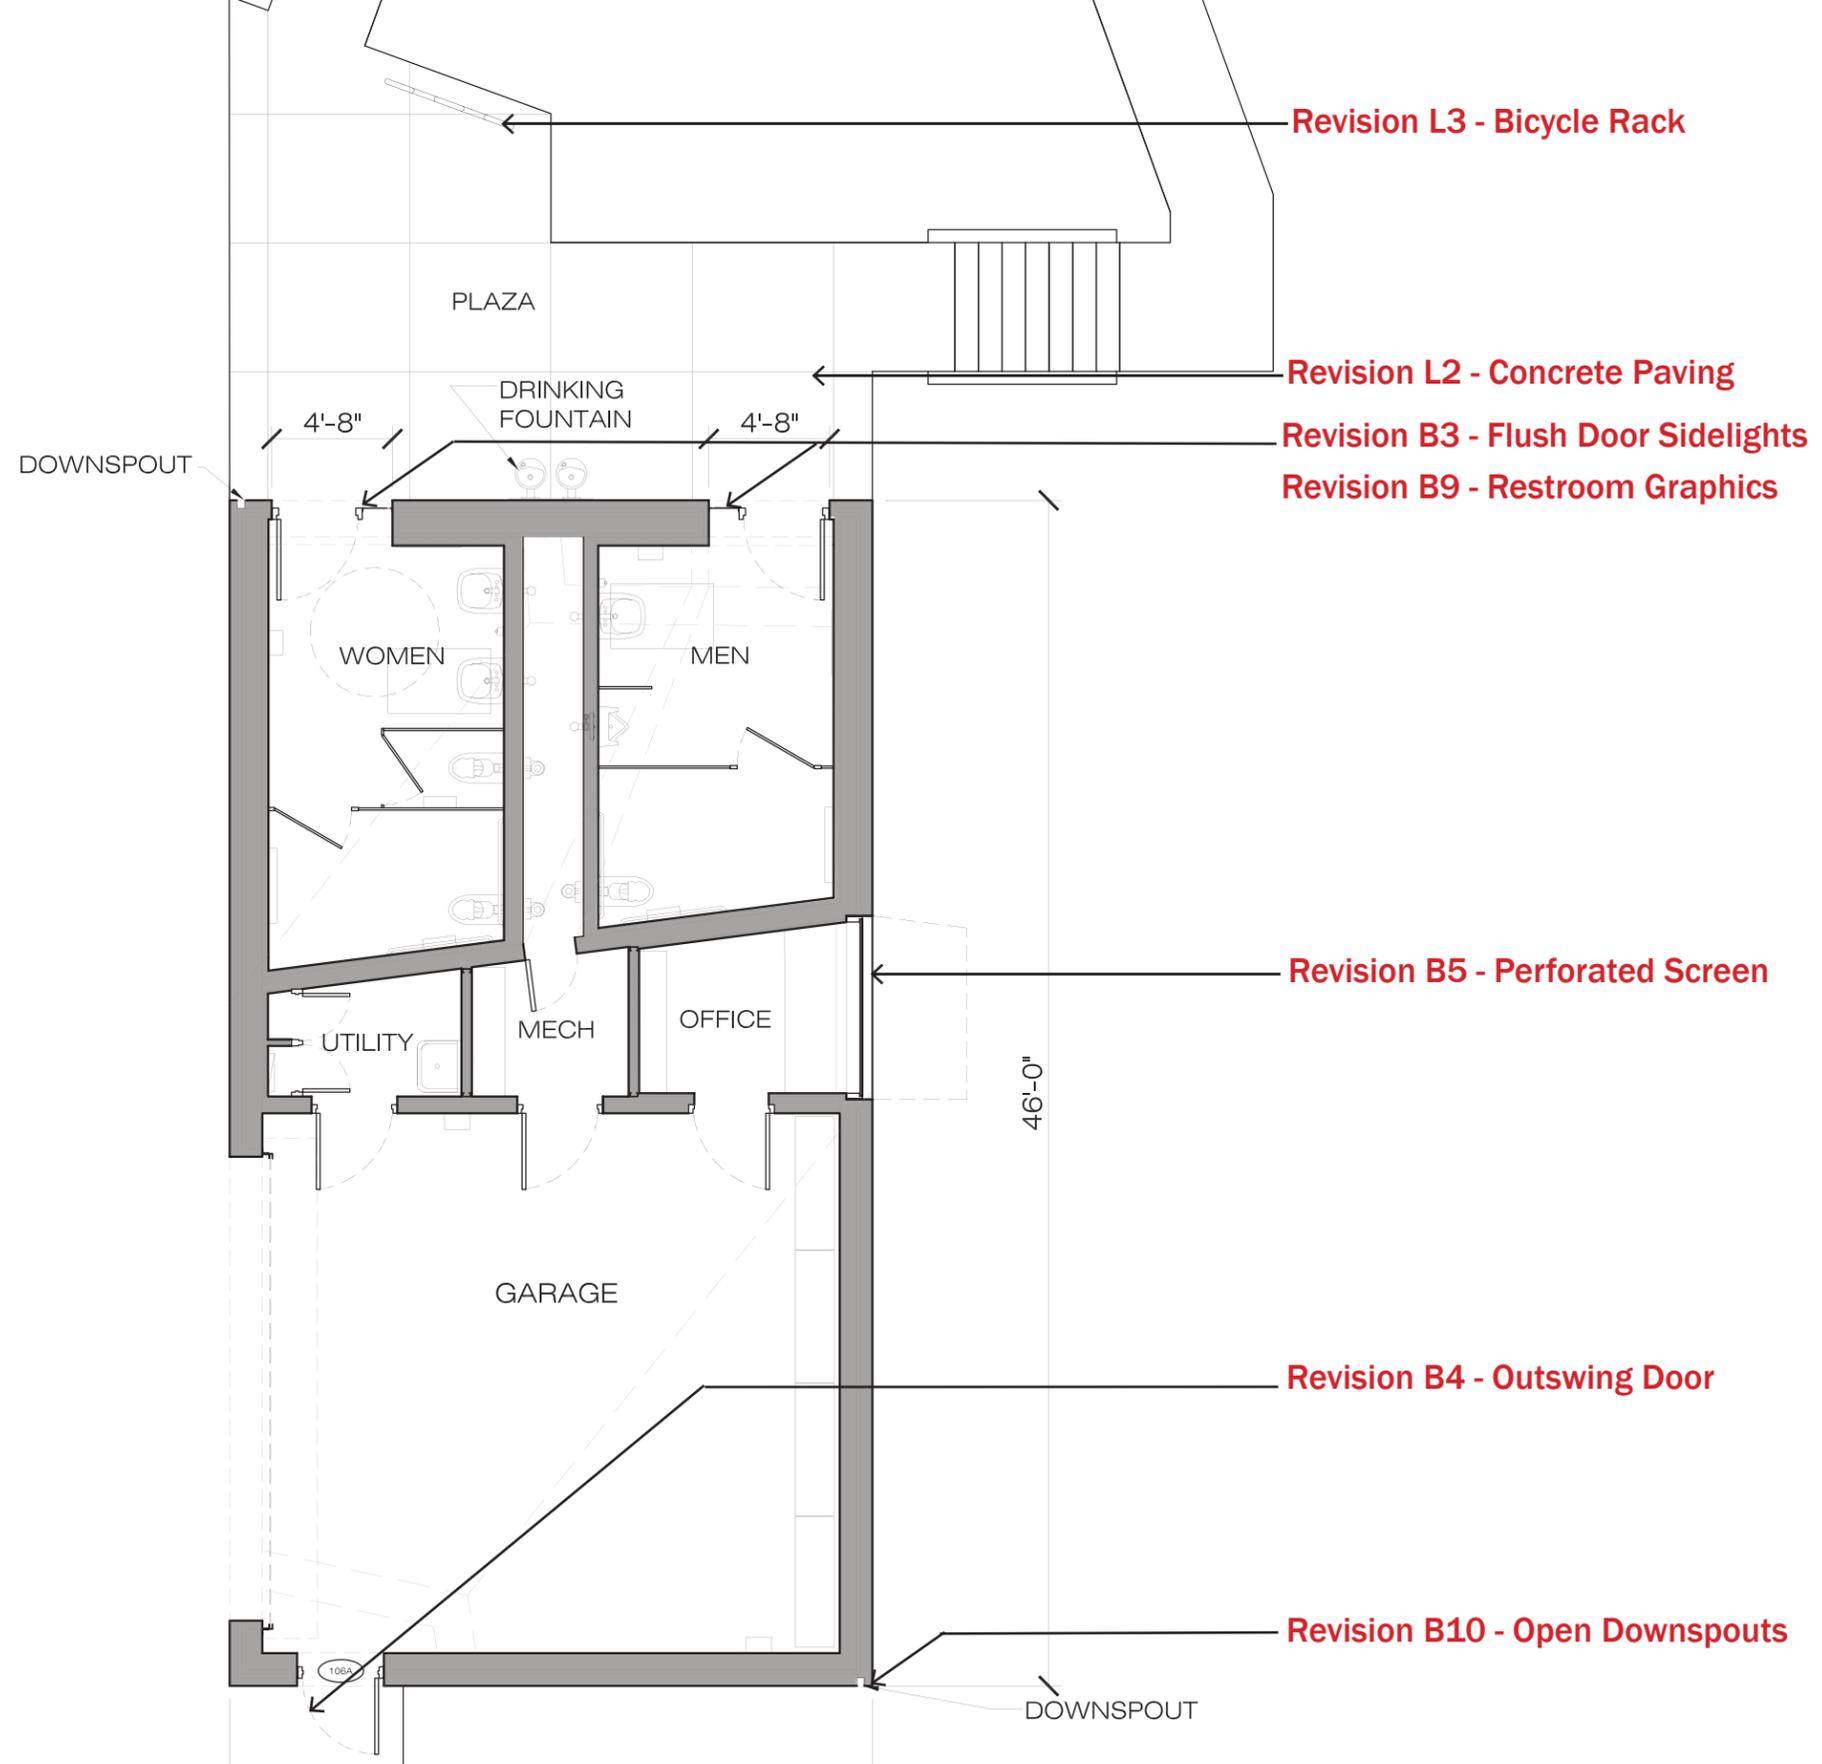

GRAY ORGANSCHI

ARCHITECTURE
 NYC DDC Department of Design and Construction




STARLIGHT PARK
 Comfort Station
 06/27/2016


Scale: 1/8" = 1'



Ground Floor Plan-Final Review

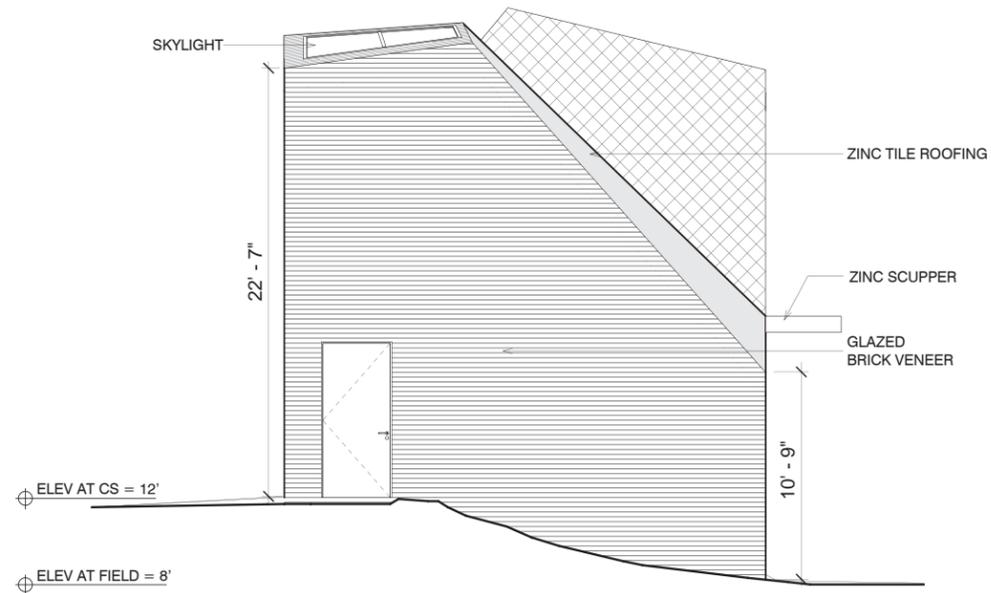


SOUTH ELEVATION

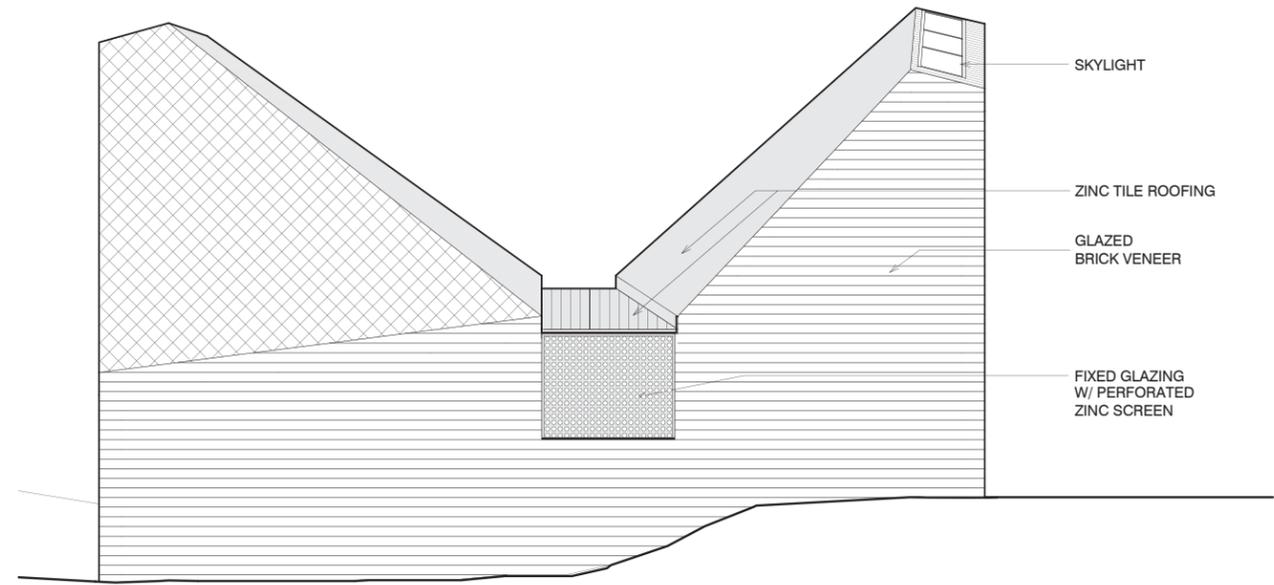

EAST ELEVATION



NORTH ELEVATION

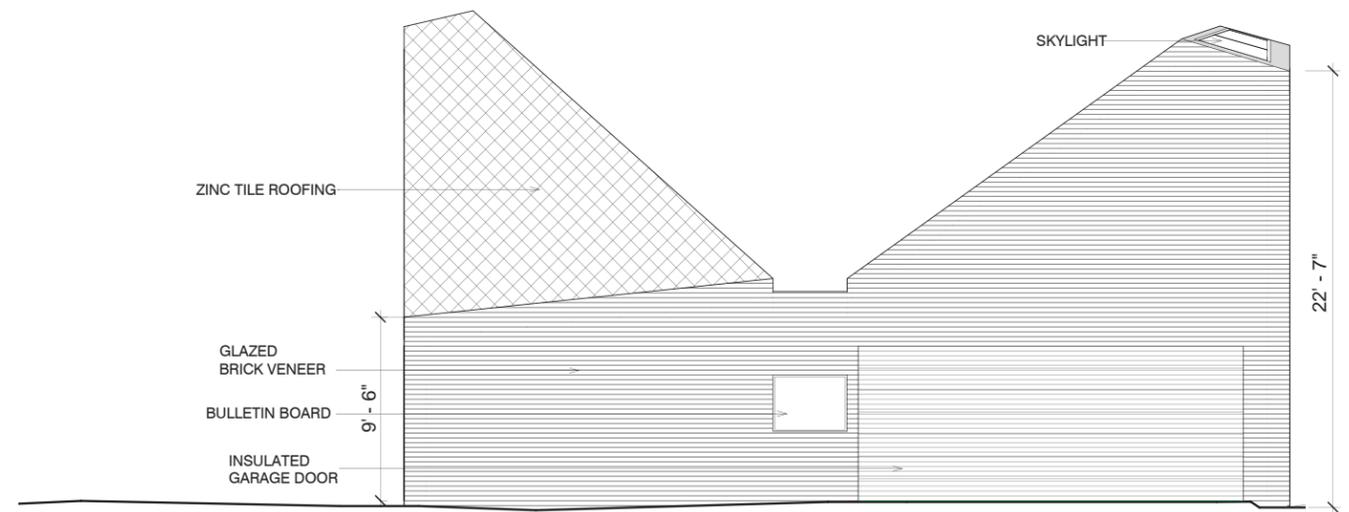


WEST ELEVATION

NOTE: MIN EAVE HEIGHT NOT BELOW 9'-0" TO PREVENT CLIMBING ON ROOF

Scale: 1/8" = 1'




Building Elevations - Approved Preliminary Elevations

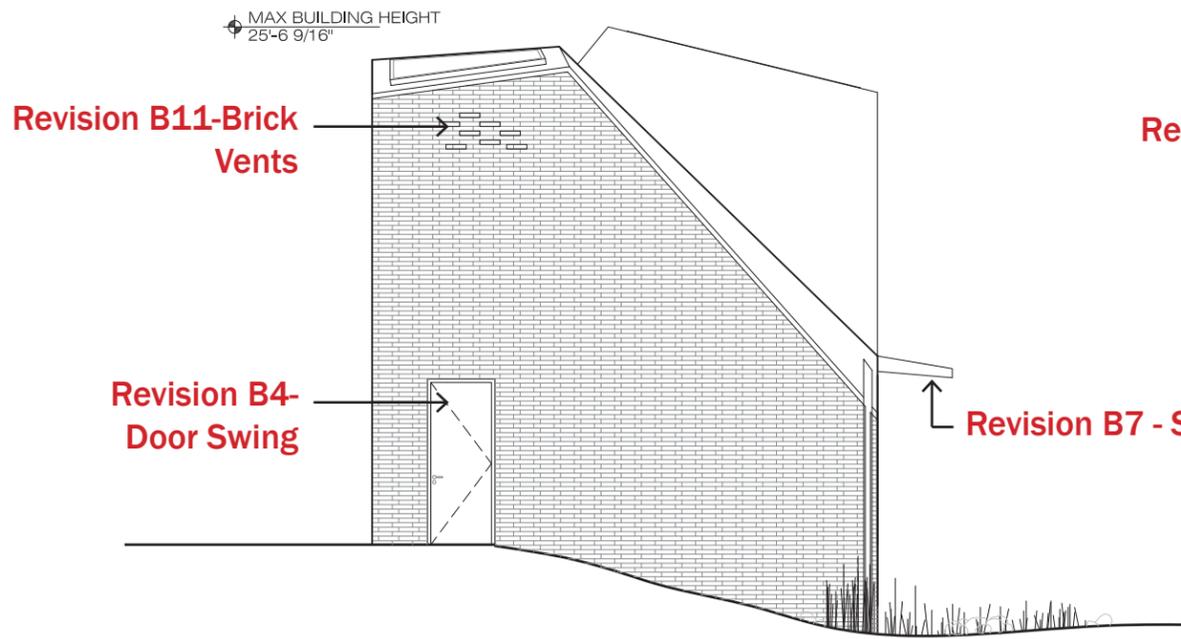

Revision B11-Brick Vents
Revision B4-Door Swing

Revision B7 - Steel Scupper

SOUTH ELEVATION

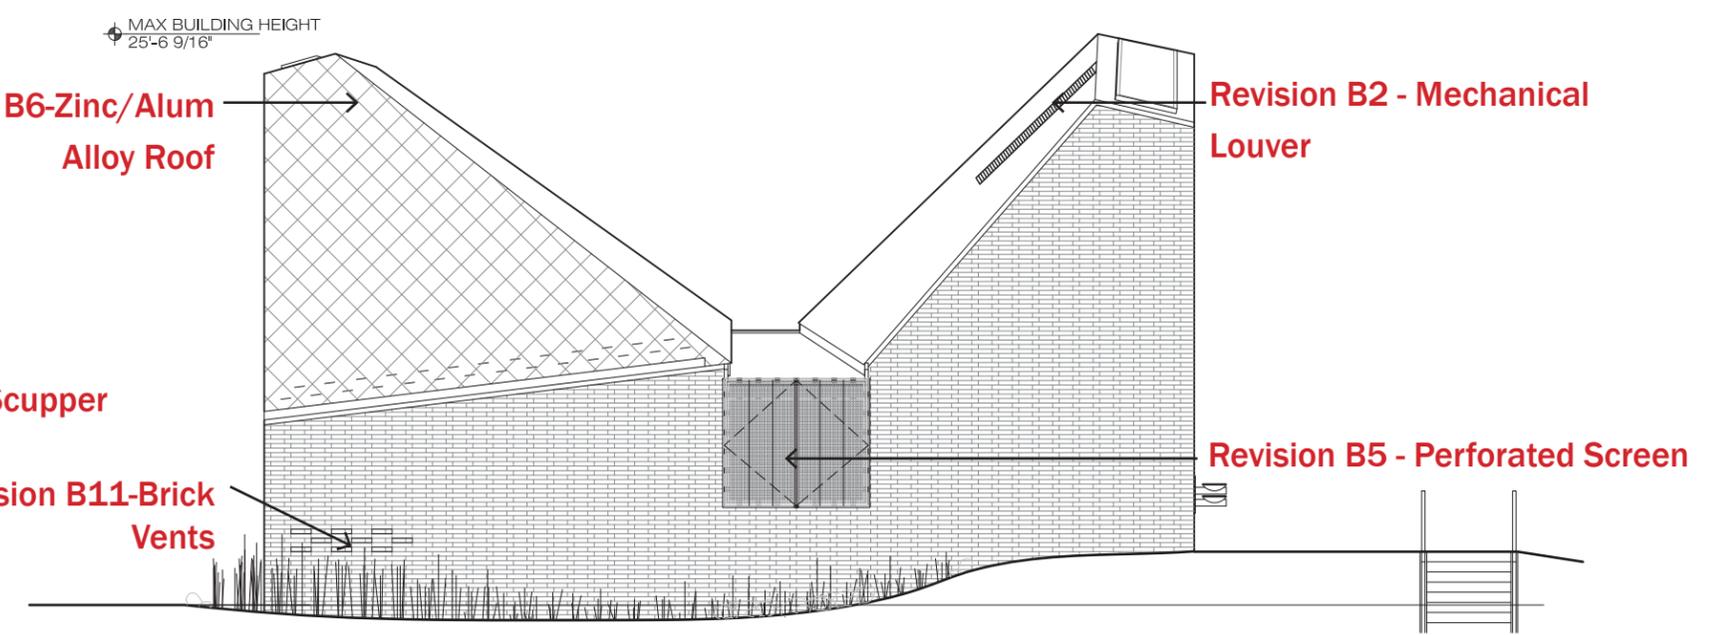


Revision B6-Zinc/Alum Alloy Roof

Revision B2 - Mechanical Louver

Revision B11-Brick Vents

Revision B5 - Perforated Screen

EAST ELEVATION

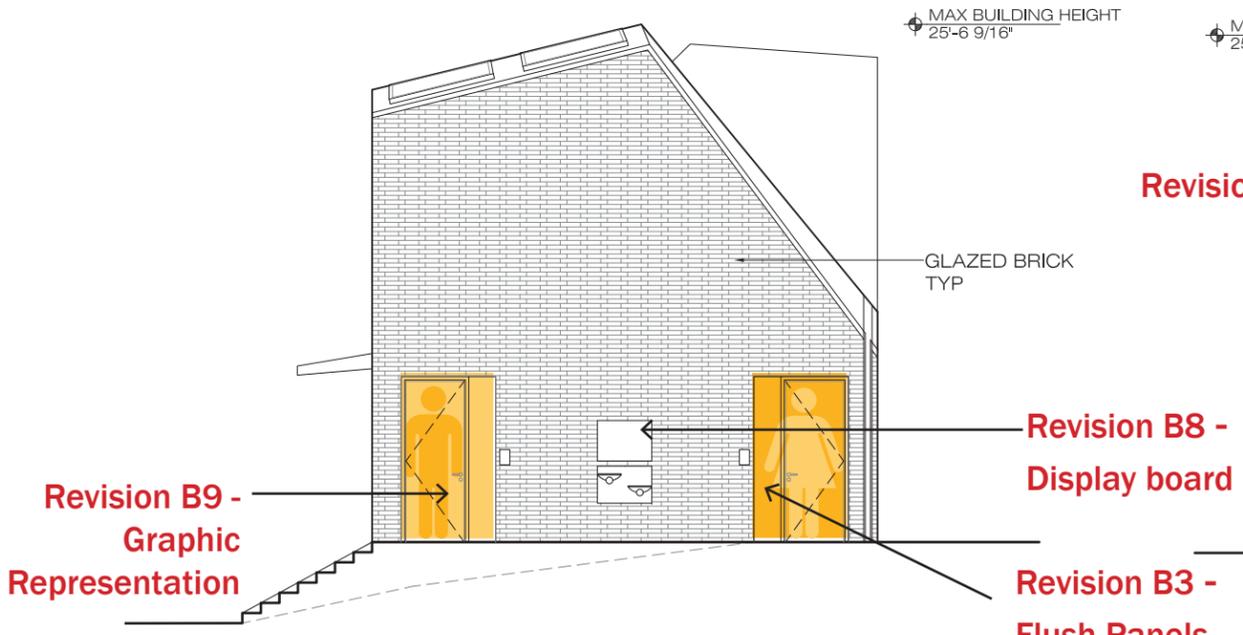


Revision B9 - Graphic Representation

GLAZED BRICK TYP

Revision B8 - Display board

Revision B3 - Flush Panels

NORTH ELEVATION

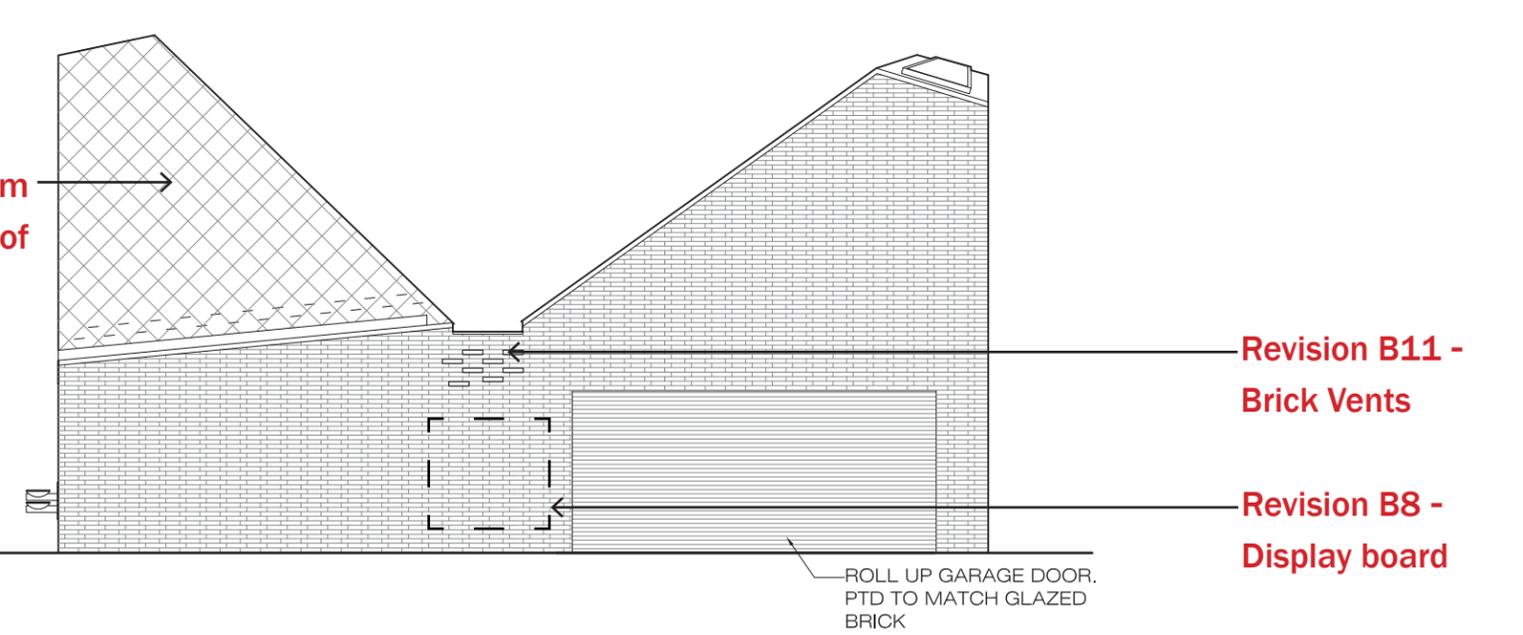

Revision B6-Zinc/Alum Alloy Roof

Revision B11 - Brick Vents

Revision B8 - Display board


ROLL UP GARAGE DOOR. PTD TO MATCH GLAZED BRICK

WEST ELEVATION

NOTE: MIN EAVE HEIGHT NOT BELOW 9'-0" TO PREVENT CLIMBING ON ROOF

Scale: 1/8" = 1'



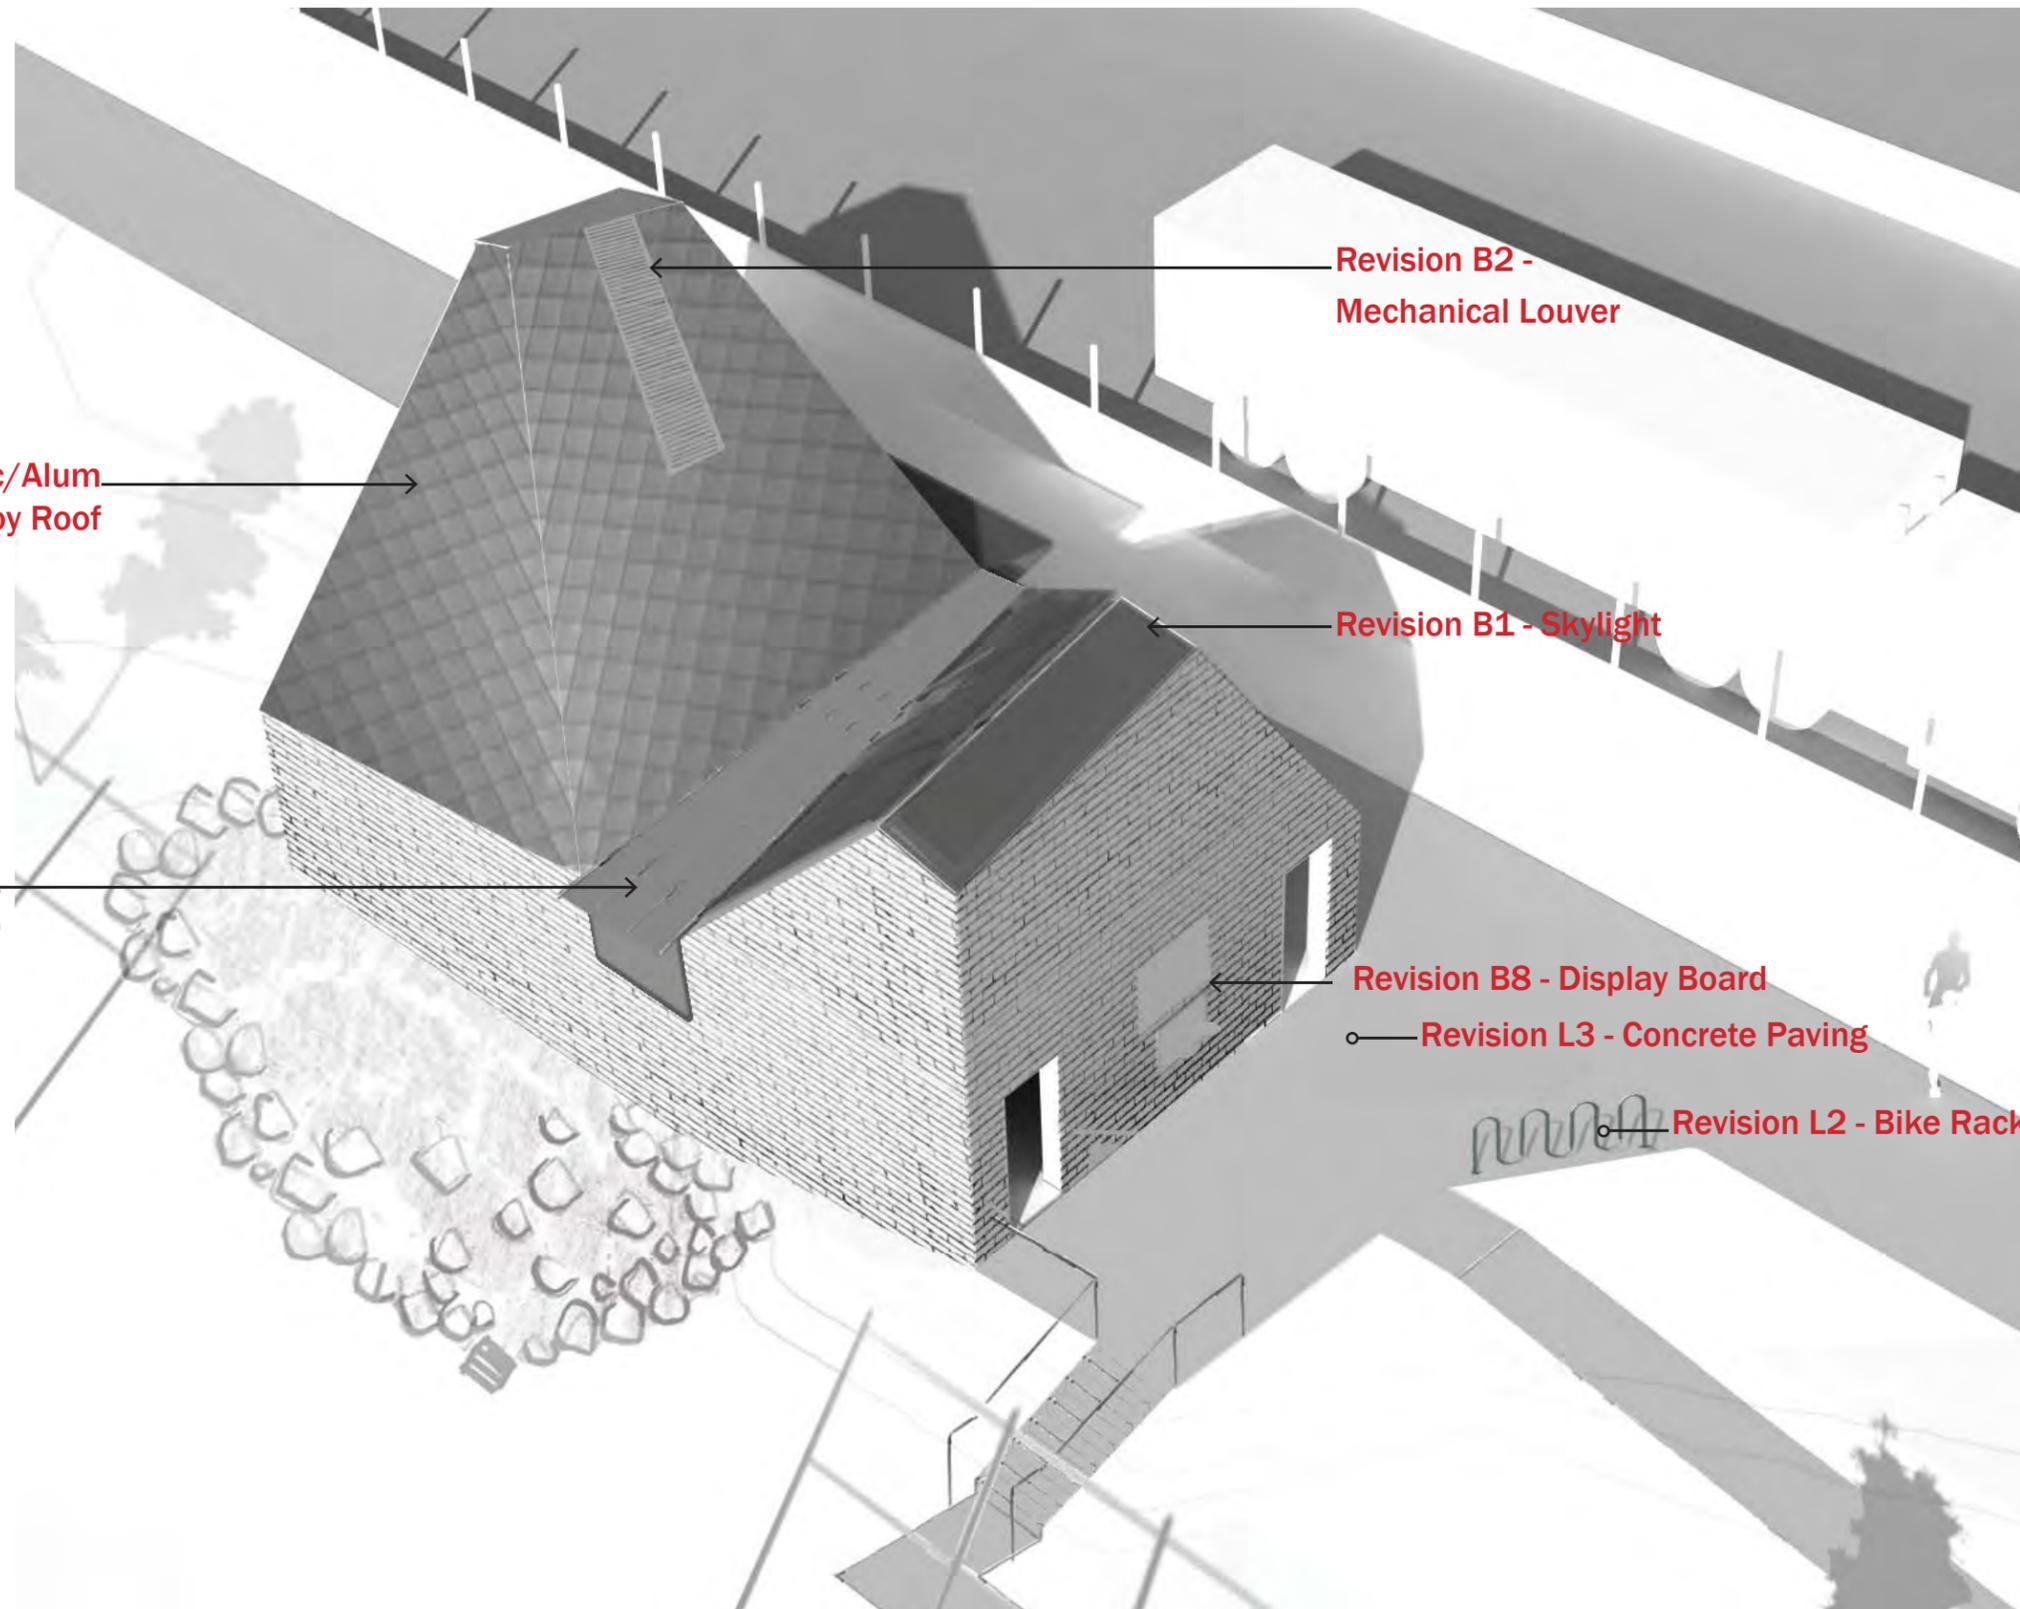

Revision B6 - Zinc/Alum Alloy Roof

Revision B2 - Mechanical Louver

Revision B1 - Skylight

Revision B7 - Steel Scupper

Revision B8 - Display Board

Revision L3 - Concrete Paving

Revision L2 - Bike Rack

GRAY ORGANSCHI

ARCHITECTURE
NYC DDC Department of Design and Construction



STARLIGHT PARK
Comfort Station
06/27/2016